


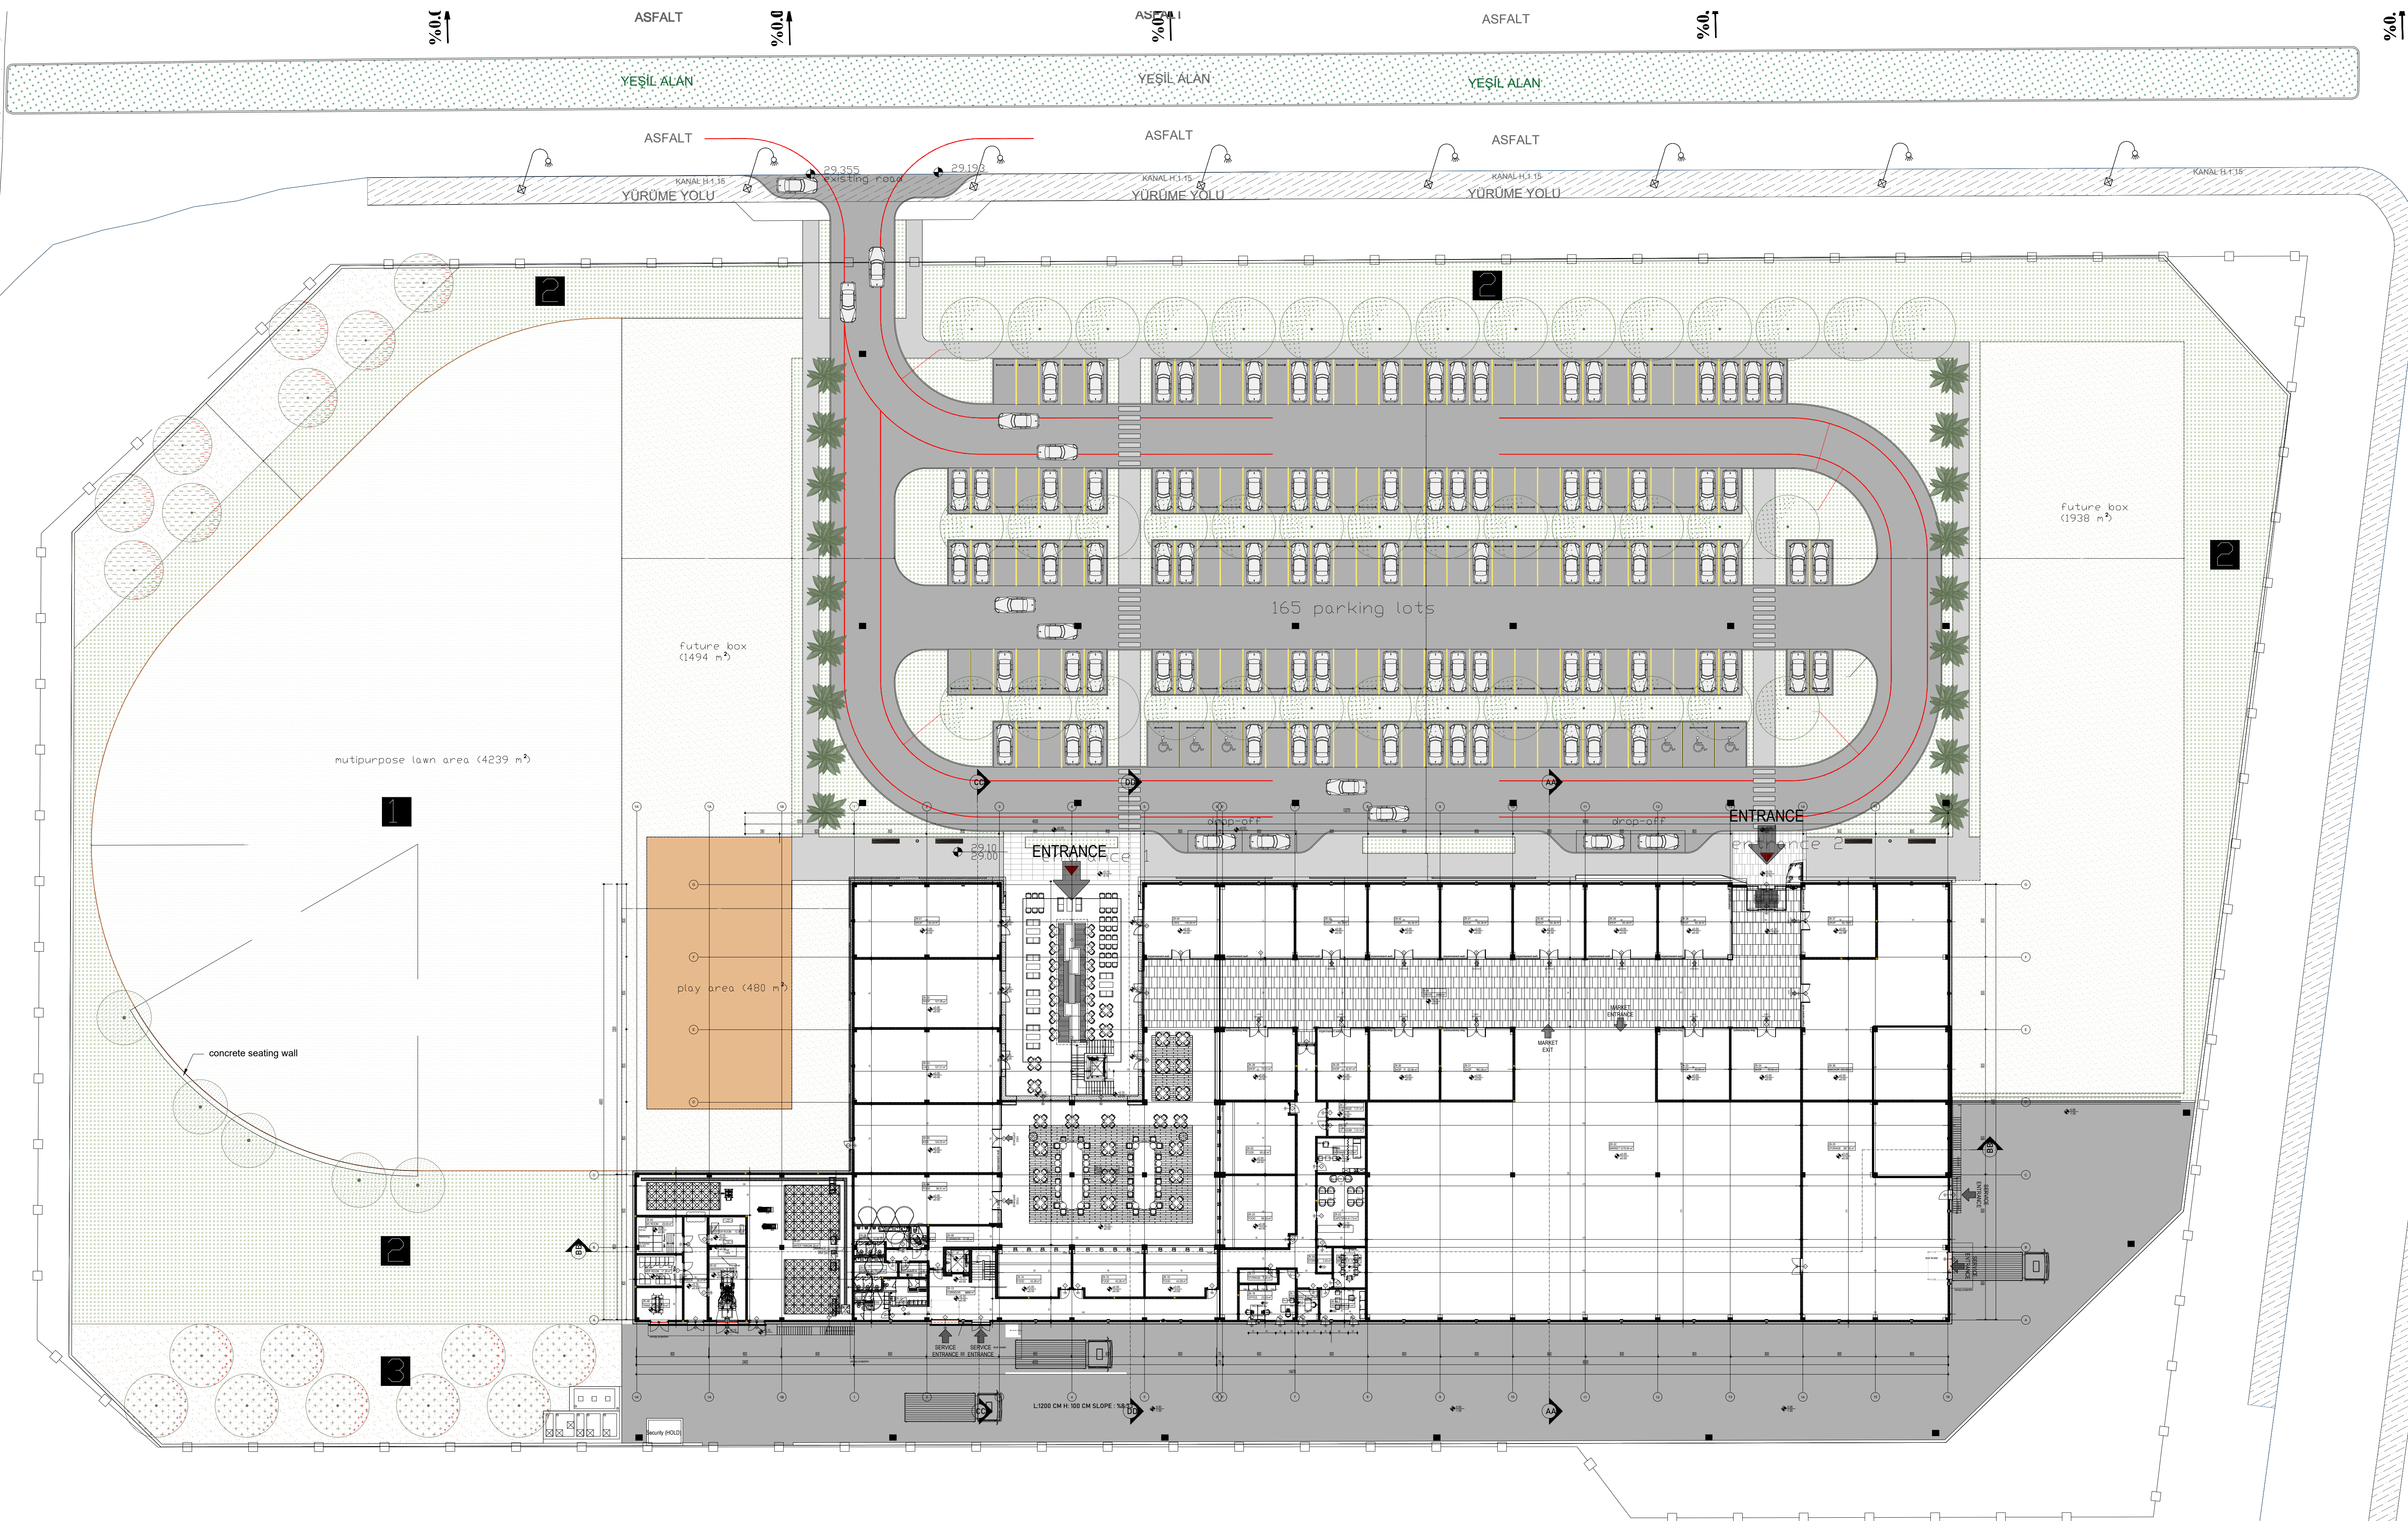

SHOP
ANCHOR
FOOD
CAFE
ENTERTAINMENT
MARKET
CIRCULATION
KIDS

NOTES ON DRAWINGS:

- All measures (dimensions) are to be taken (checked) on site.
- All dimensions are in centimeters and to the masonry surfaces, at elevations are in meters. All levels are in meters.
- Top of slab (T.O.S.) on ground floor (±0.00) is equal to (±0.50).
- Any queries to be clarified with the Architect.
- All vertical measures relate to the SSL.
- All door heights are measured from the SSL to rough opening.
- All parapet heights are measured from SSL to top of rough parapet.
- All windows and doors without tags are defined in facade drawings.
- For fire-protection ratings of primary and finishing elements see "FP" Fire Protection Plans and Report.
- If dimensions of structural elements in architectural plans differ from structural plans, structural plans overrule architectural plans.
- Provide safety attachment points on the roof as required where parapet height is less than 110 cm above finished roof.
- For all MEP disciplines and distributions see MEP plans and reports.
- For suspended ceiling dimensions and levels refer to suspended ceiling plans.

Note: Medical equipment placement and furnishing in drawings are for only sampling and relevant with reality.
Exact placement and furnishing will be submitted by application drawings.

REV NO	DATE	REVISION EXPLANATION
--------	------	----------------------

KEY PLAN

PROJECT CODE	PROJECT NAME
SSM	DIAMNIADIO PLAZA

CLIENT	COMMERCIAL DEVELOPMENT SARL
--------	-----------------------------

MAIN CONTRACTOR	SUMMA SENEGAL
-----------------	---------------

ARCHITECT	CABINET D'ARCHITECTURE ALIOUNE SOW
-----------	------------------------------------

DESIGN ARCHITECT & INTERIOR DESIGN	IGR IGLO MINARLIK PROJE INSAATI SAN TIC LTD. STI
------------------------------------	--

STRUCTURAL	EMR INSAAT MÜHÜRÜSÜ İNŞAAT VE TİC. LTD. STI
------------	---

MECHANICAL	METTA MÜHÜRÜSÜK MÜSAVİRLİK TİCARET LTD. STI
------------	---

ELECTRICAL	WHO Mühendislik ve Danışmanlık Hizmetleri A.Ş.
------------	--

LIGHTING	MCC MCC LIGHTING DESIGN AND CONSULTANCY
----------	---

LANDSCAPE	3AD PROJECT ARCHITECTURE ENGINEERING CONSTRUCTION eod project TOURISM IND AND COM. CO. LTD.
-----------	--

NOT FOR CONSTRUCTION ☐	FOR CONSTRUCTION ☐	FOR TENDER ☐
---	---	-------------------------------------

DRAWN BY	ZAFER KAROĞLU
----------	---------------

CHECKED	YILDIRIM GIGI
---------	---------------

APPROVAL	
----------	--

STAGE	DATE	SCALE
-------	------	-------

CD	13.12.2024	1/100
----	------------	-------

SHEET NAME

GROUND FLOOR PLAN

SHEET NO

SSM-A-X-RP-CD-01-02

PROJECT NO	DISCIPLINE	PHASE	SERIE	NO	REV NO
------------	------------	-------	-------	----	--------

SSM	M	CD	CS	102	R00
-----	---	----	----	-----	-----